



*Atlantic Sunrise Project – PA DEP Chapter 105 Joint Permit Application
Transcontinental Gas Pipe Line Company, LLC
Schuylkill County*

**APPENDIX L -4
HYDROTEST PLANS**


Revised April 2017

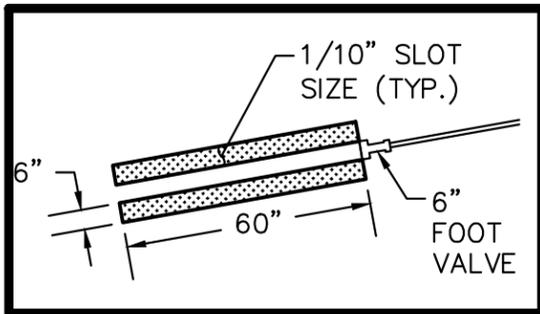

INSET A
SHALLOW WATER INTAKE
NOT TO SCALE

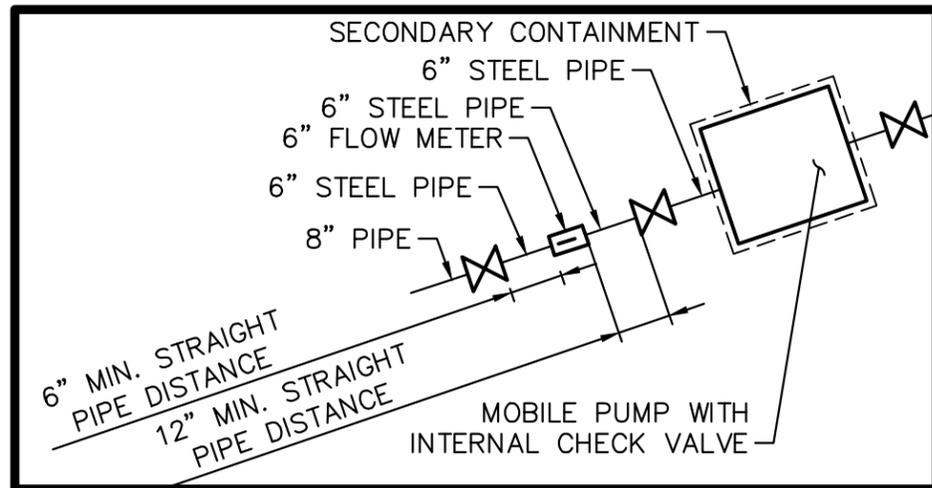

INSET B
PUMP & FLOW METER
NOT TO SCALE

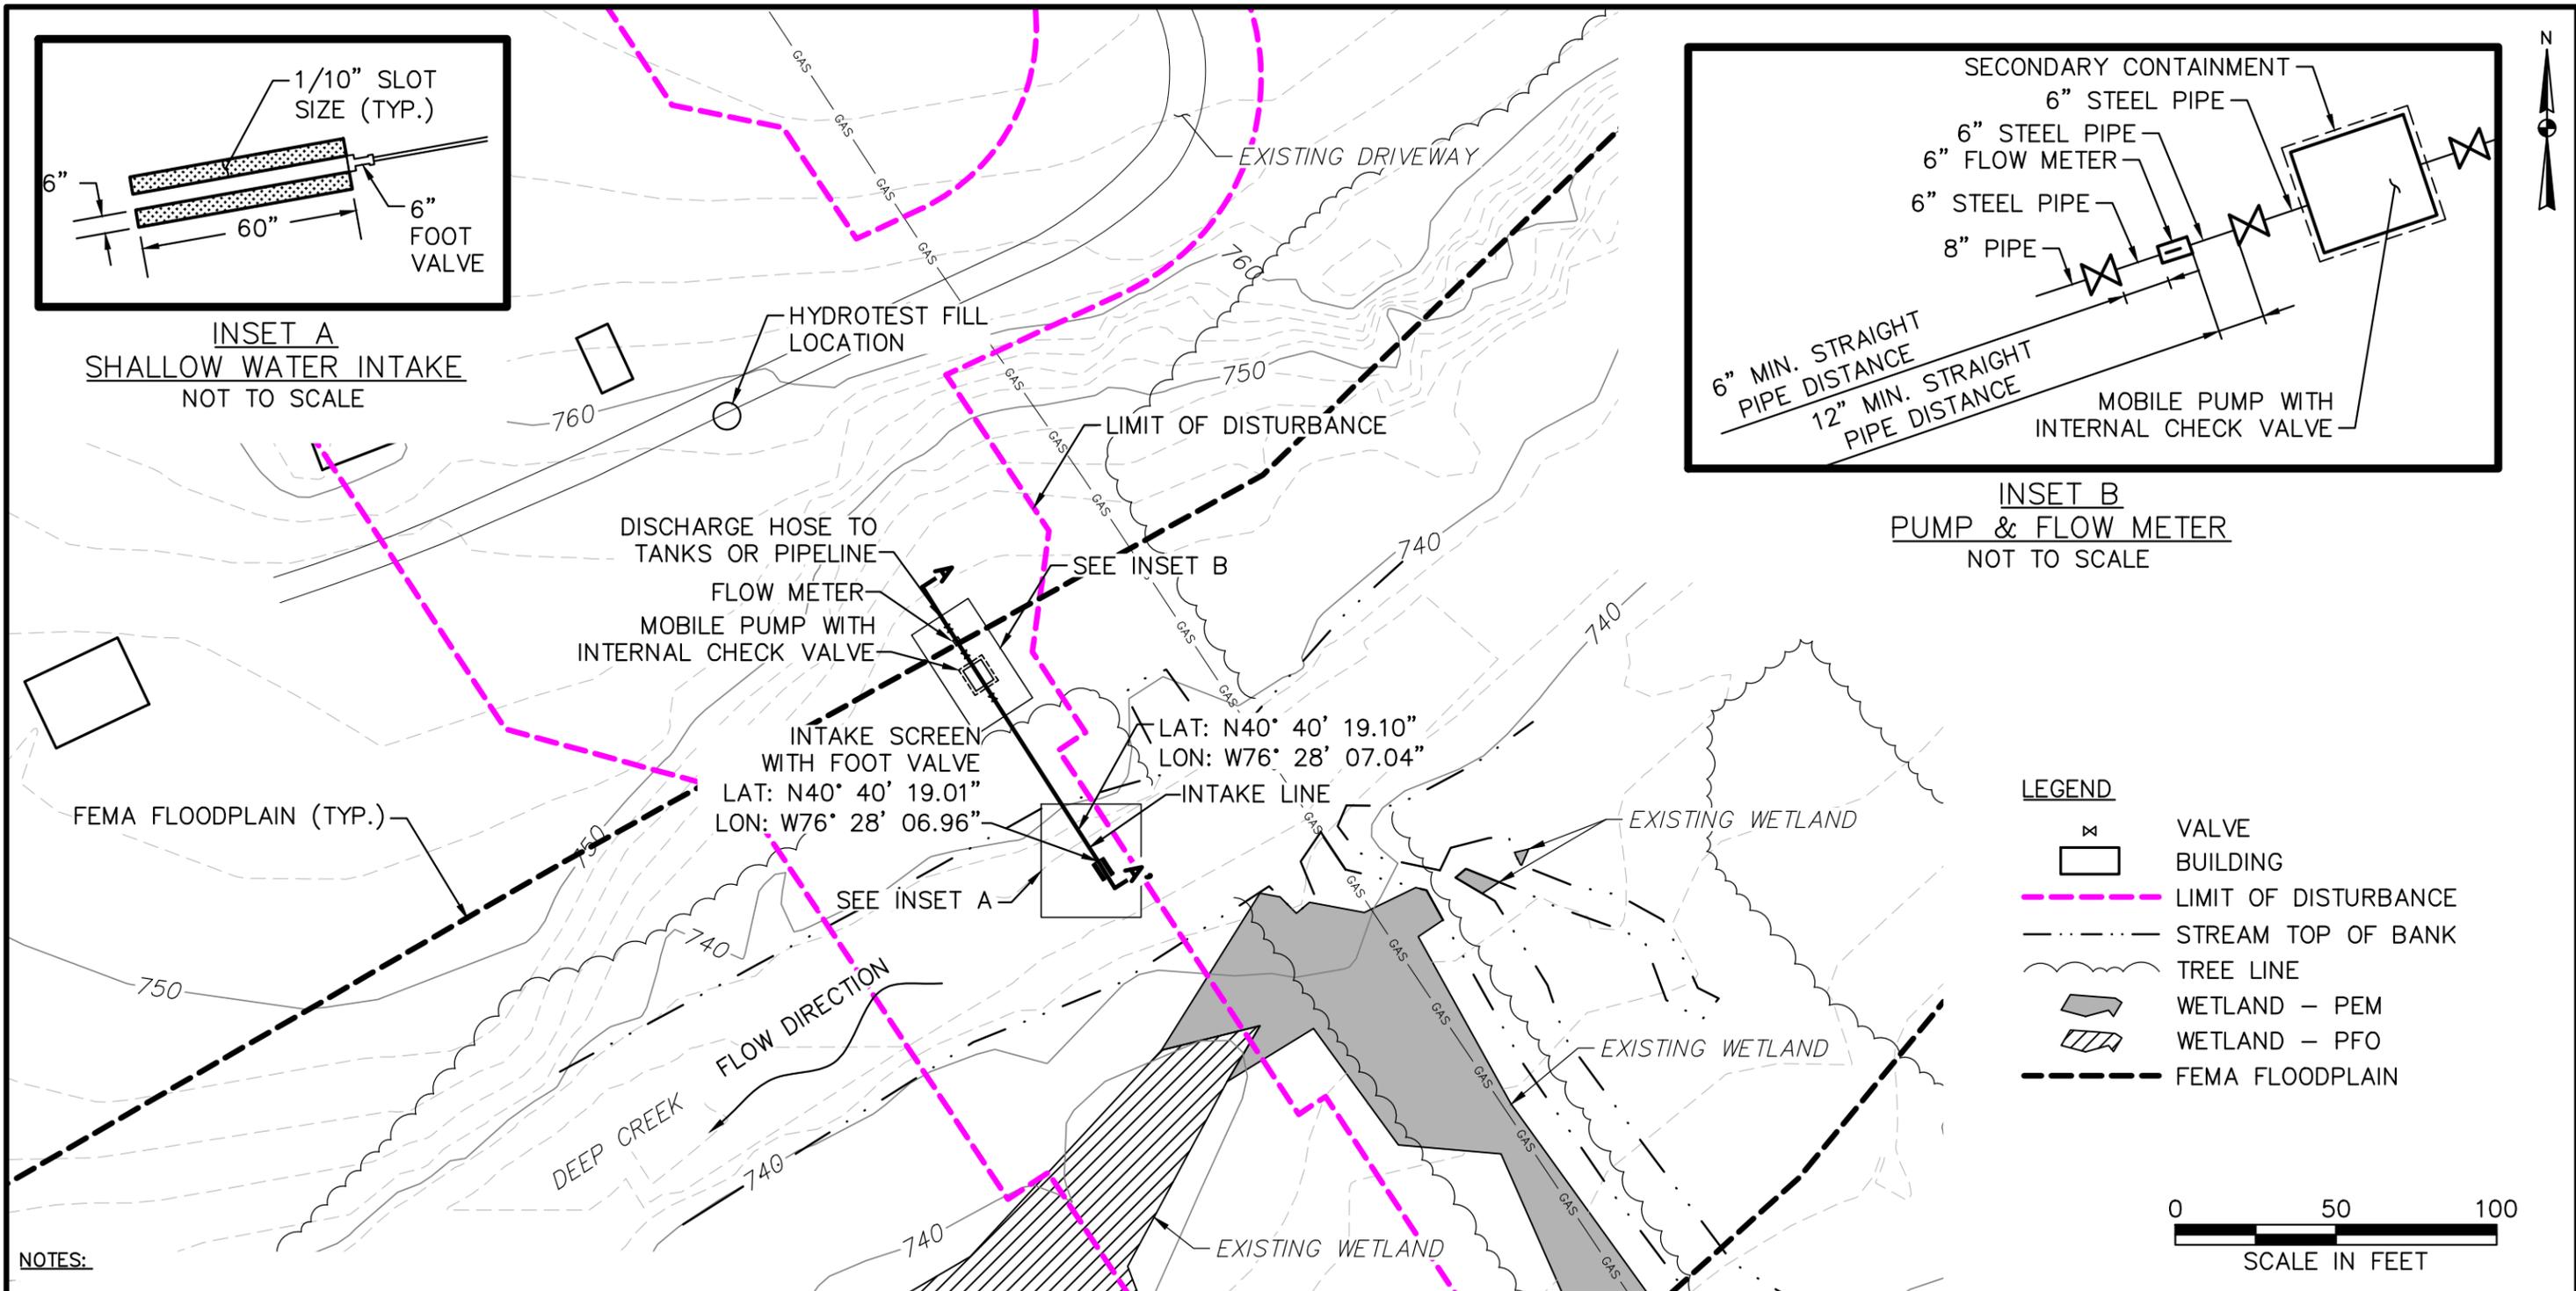

LEGEND

	VALVE
	BUILDING
	LIMIT OF DISTURBANCE
	STREAM TOP OF BANK
	TREE LINE
	WETLAND - PEM
	WETLAND - PFO
	FEMA FLOODPLAIN



- NOTES:**
- SURVEY DATUM:**
HORIZONTAL: PA STATE PLANE NAD83
VERTICAL: NAVD88
 - STORAGE TANKS WILL BE LOCATED IN A FIELD ADJACENT TO FOOLS PARADISE LANE APPROXIMATELY 0.12 MILES NORTHWEST OF THE WITHDRAWAL POINT. STORAGE TANKS WILL BE USED DURING MONTHS WHEN WITHDRAWAL RATES ARE LESS THAN 1,200 GPM.
 - PLACEMENT OF HYDROSTATIC WATER WITHDRAWAL EQUIPMENT WILL HAVE NO EARTH DISTURBANCE AND IS TEMPORARY IN NATURE.



TETRA TECH



WWW.TETRATECH.COM

661 ANDERSEN DRIVE - FOSTER PLAZA 7
PITTSBURGH, PA 15220
T: (412) 921-7090 | F: (412) 921-4040

TRANSCONTINENTAL GAS PIPE LINE COMPANY, LLC
DEEP CREEK, HEGINS TWP, SCHUYLKILL CO.

SITE PLAN

DATE:	08/12/16
PROJECT NO.:	212C-PB-00282
DESIGNED BY:	RD
DRAWN BY:	CK
CHECKED BY:	CR
SHEET:	1 OF 2
COPYRIGHT TETRA TECH INC.	
FIGURE 8-2	

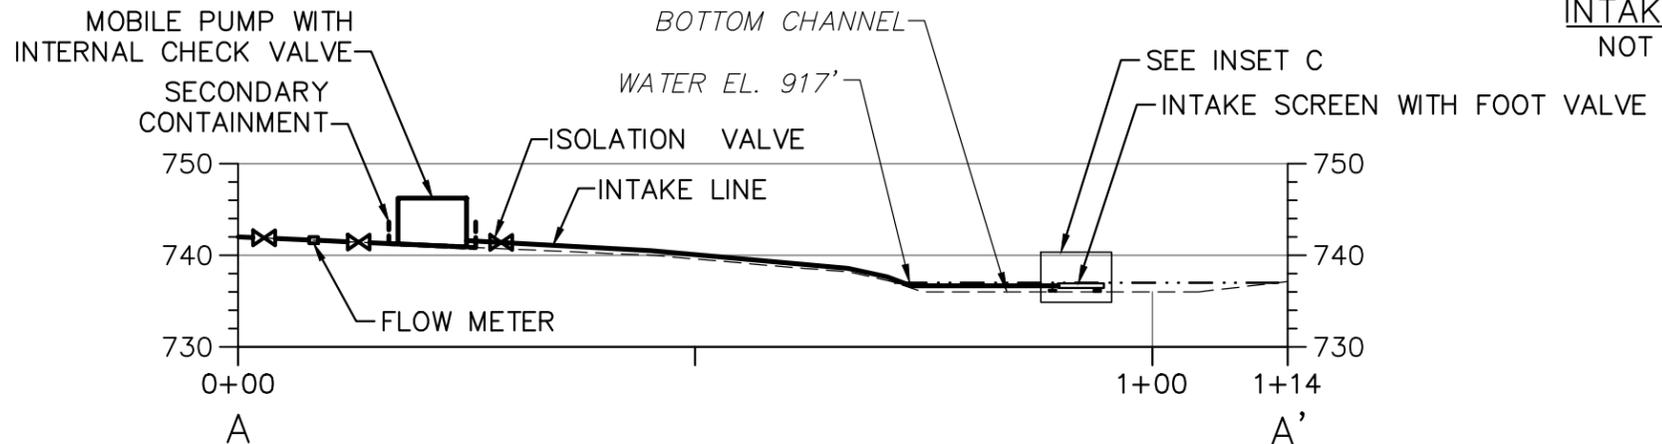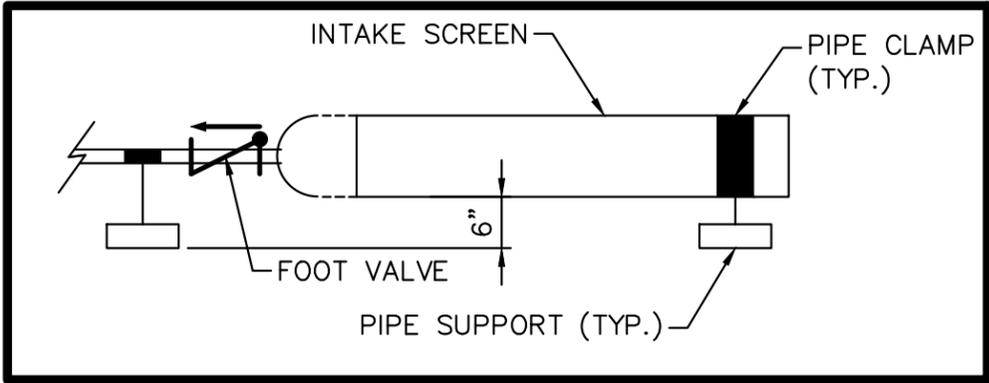

CROSS-SECTION A-A'



NOTES:
 SURVEY DATUM:
 HORIZONTAL: PA STATE PLANE NAD83
 VERTICAL: NAVD88

 TETRA TECH <small>WWW.TETRATECH.COM</small>	661 ANDERSEN DRIVE – FOSTER PLAZA 7 PITTSBURGH, PA 15220 T: (412) 921-7090 F: (412) 921-4040
---	--

TRANSCONTINENTAL GAS PIPE LINE COMPANY, LLC
 DEEP CREEK, HEGINS., SCHUYLKILL CO.

CROSS-SECTION OF INTAKE SYSTEM

DATE:	9/16/15
PROJECT NO.:	212C-PB-00282
DESIGNED BY:	RD
DRAWN BY:	CK
CHECKED BY:	CR
SHEET:	2 OF 2

COPYRIGHT TETRA TECH INC.
FIGURE 8-3